



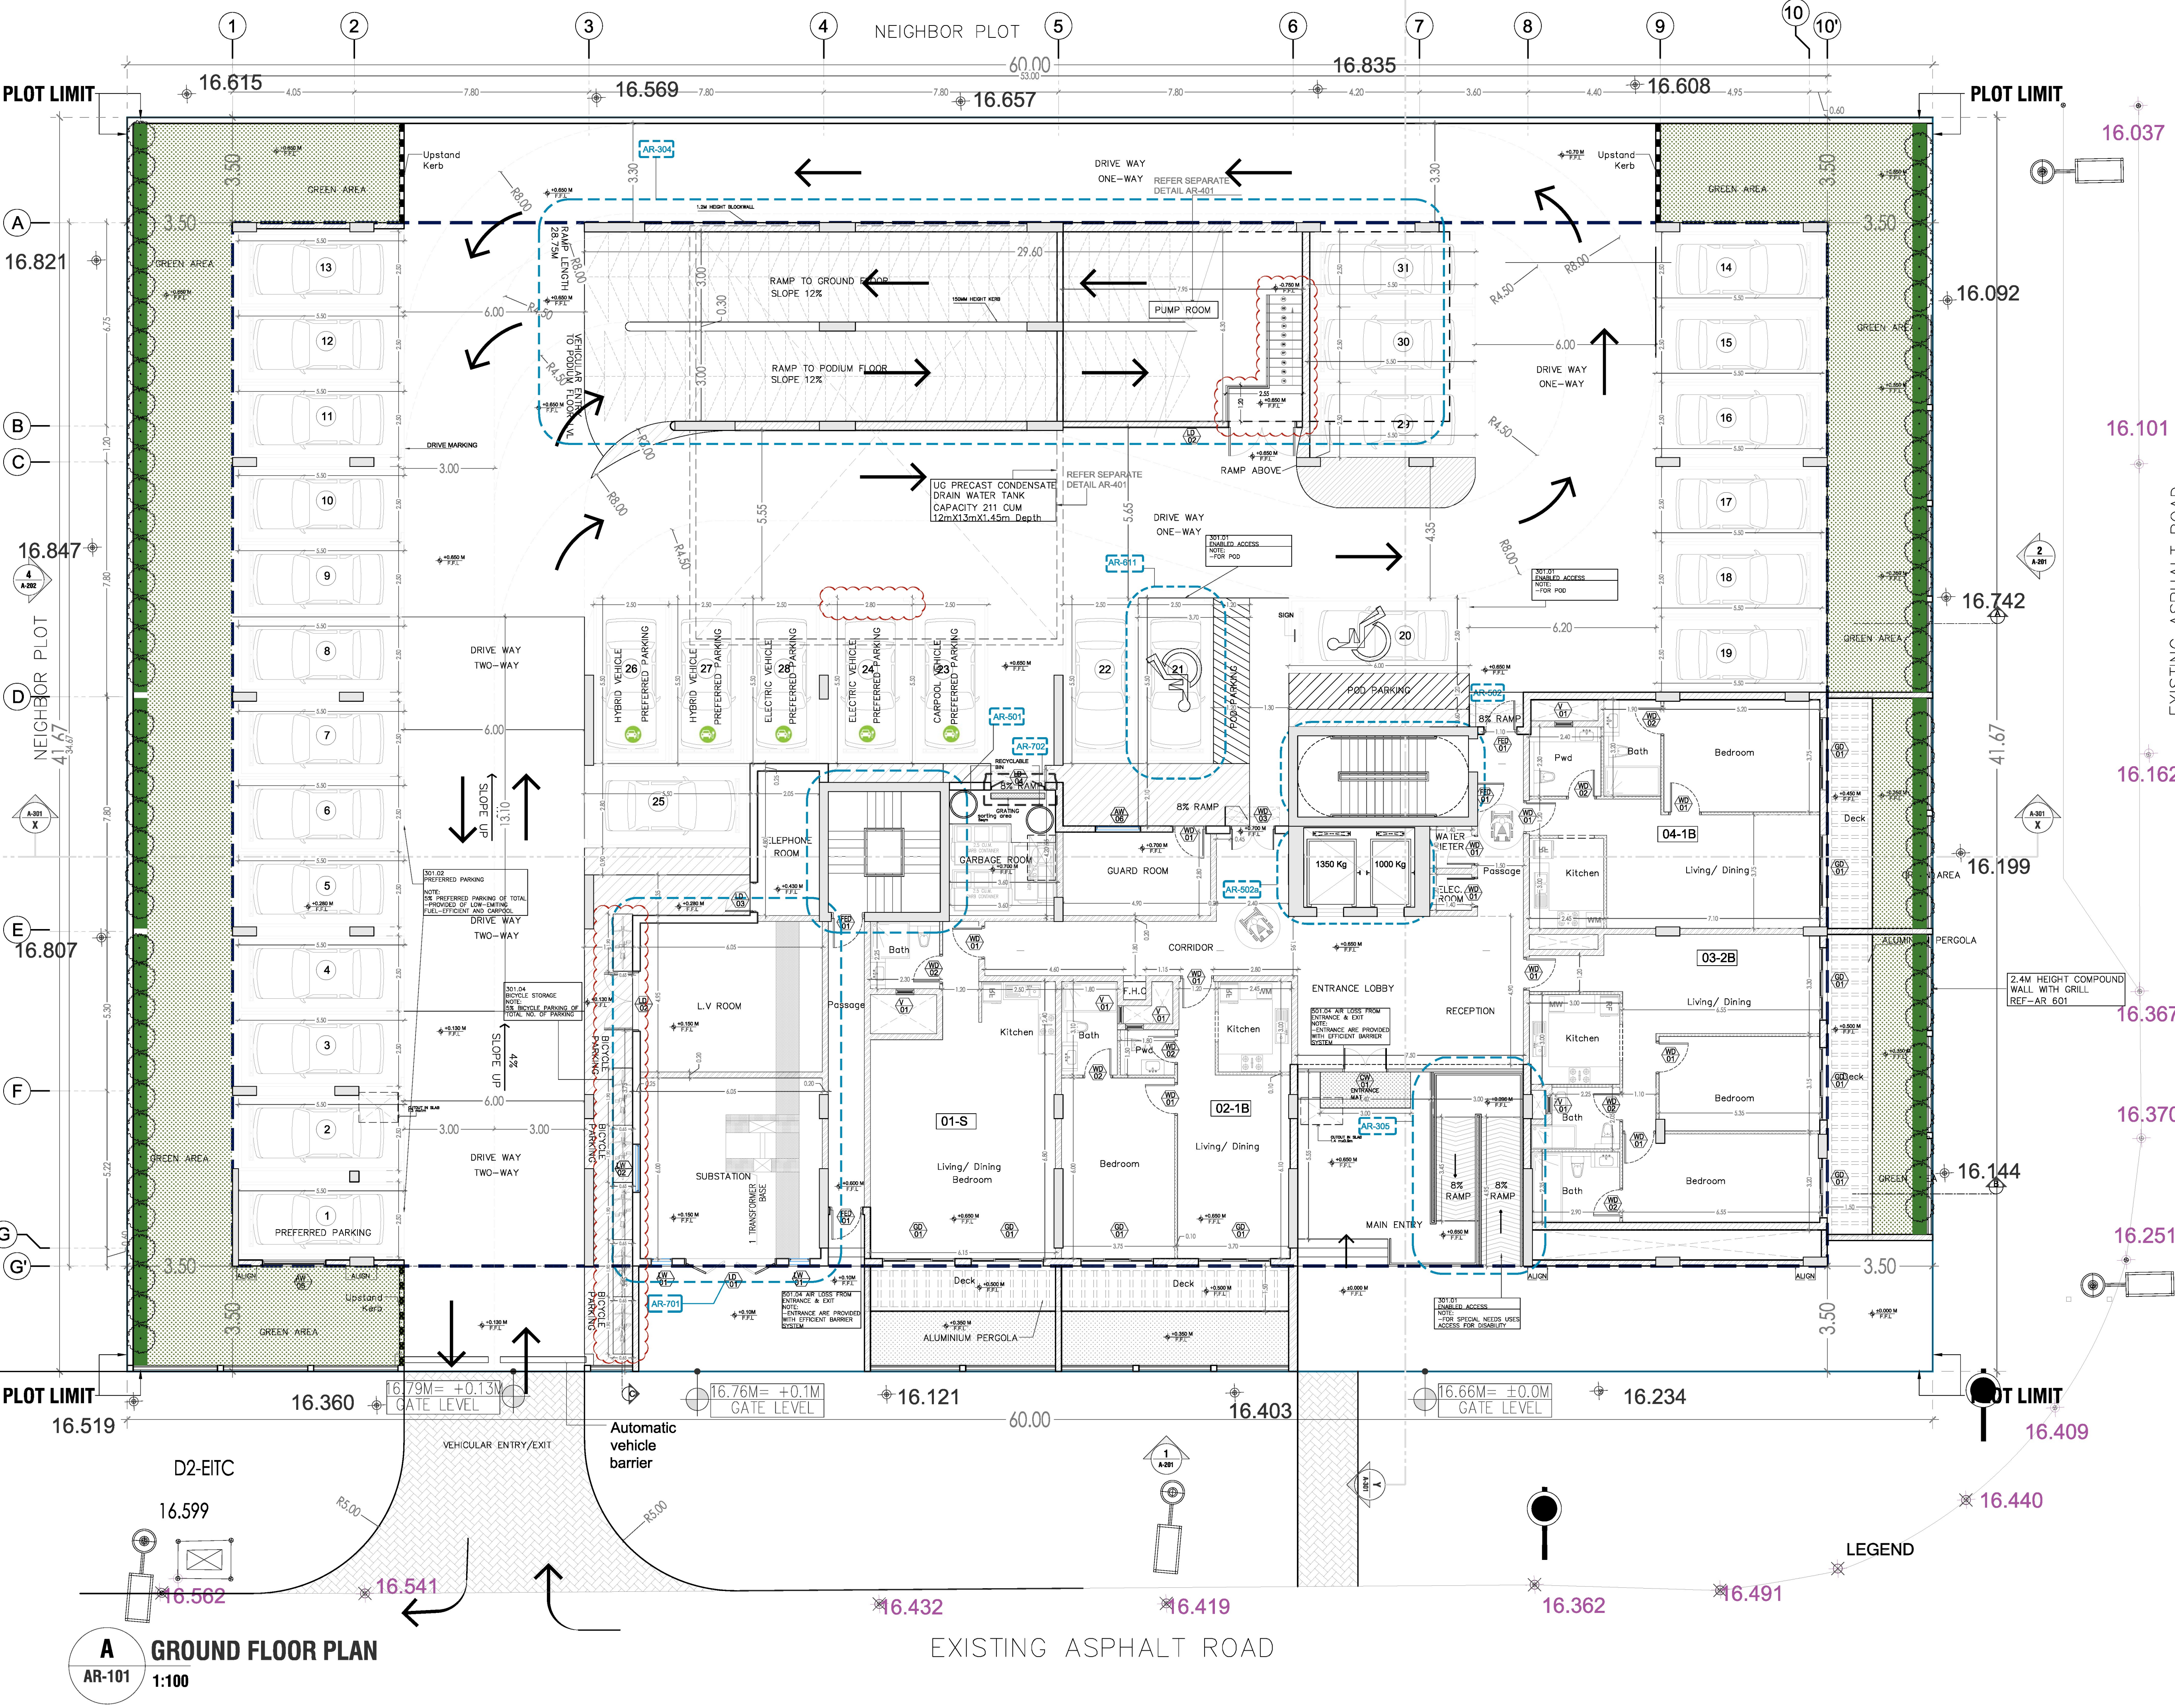

- GENERAL NOTES:**
1. ALL DIMENSIONS ARE IN MILLIMETERS. UNLESS OTHERWISE SPECIFIED.
 2. DO NOT SCALE THE DRAWINGS.
 3. ALL MATERIALS SHOULD BE APPROVED BY THE CONSULTANT.
 4. DO NOT COVER ANY INTERNAL EXECUTION WORKS BEFORE CHECKED AND APPROVED BY THE CONSULTANT.
 5. DO NOT COMMENCE THE WORK UNLESS THE DRAWING IS ISSUED FOR CONSTRUCTION.
 6. CONTRACTOR SHOULD SUBMIT THE SHOP DRAWING FOR APPROVAL.
 7. EXAMINE THE DRAWINGS, CAREFULLY BEFORE COMMENCING THE WORKS. REPORT TO THE CONSULTANT AND OBTAIN CLARIFICATIONS OR ADDITIONAL INSTRUCTIONS BEFORE PROCEEDING.
 8. ALL PLANS, DRAWINGS, GRAPHICS REPRESENTATIONS, AND SPECIFICATIONS PREPARED BY THE CONSULTANT ARE INSTRUMENT OF SERVICES FOR CARRYING OUT A PROJECT.

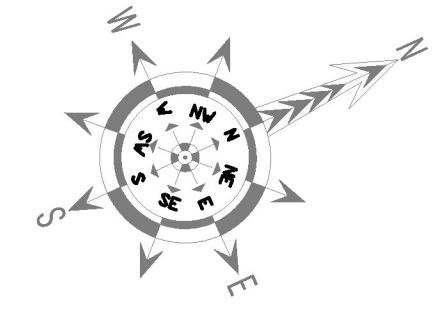


LEGEND

---	SETBACK LINE
---	PROPOSED BUILDING LINE
---	PLOT LIMIT
XX.XXX	GROUND LEVELS
XX.XXX	ASPHALT LEVELS




AS REVISED

MINOR MODIFICATION AS PER DCD	08.07.2024	R1
DESCRIPTION	DATE	REV
CONSULTANT:		
CORPORATE PLANNERS		
ENGINEERING CONSULTANTS		
P.O. Box 31548, DUBAI UNITED ARAB EMIRATES.		
Tel: -04-2779058 Fax: -04-2779059, Email: cpec@cpecdxb.ae		
CLIENT:		
MR. FIROZ LATIF MANJOTHJI		
JOB TITLE:		
PROPOSED G+P+4+R APARTMENT		
@ INTERNATIONAL CITY PHASE 2 AND 3		
ON PLOT NO IC3-D-02		
DRAWING TITLE:		
GROUND FLOOR PLAN		
JOB NO.	DRAWN	SARA
SCALE: 1:100	DATE: NOV 2023	STRUC.
CORPORATE PLANNERS ENGINEERING CONSULTANTS reserve the ownership of this drawing under the law. All rights on this drawing rest at all times with our company. This drawing is issued on the condition that it is not copied, reproduced, related or disclosed to any unauthorized person either wholly or in part without the consent in writing of the CORPORATE PLANNERS ENGINEERING CONSULTANTS.		
DRAWING NO.: AR-101		REV.

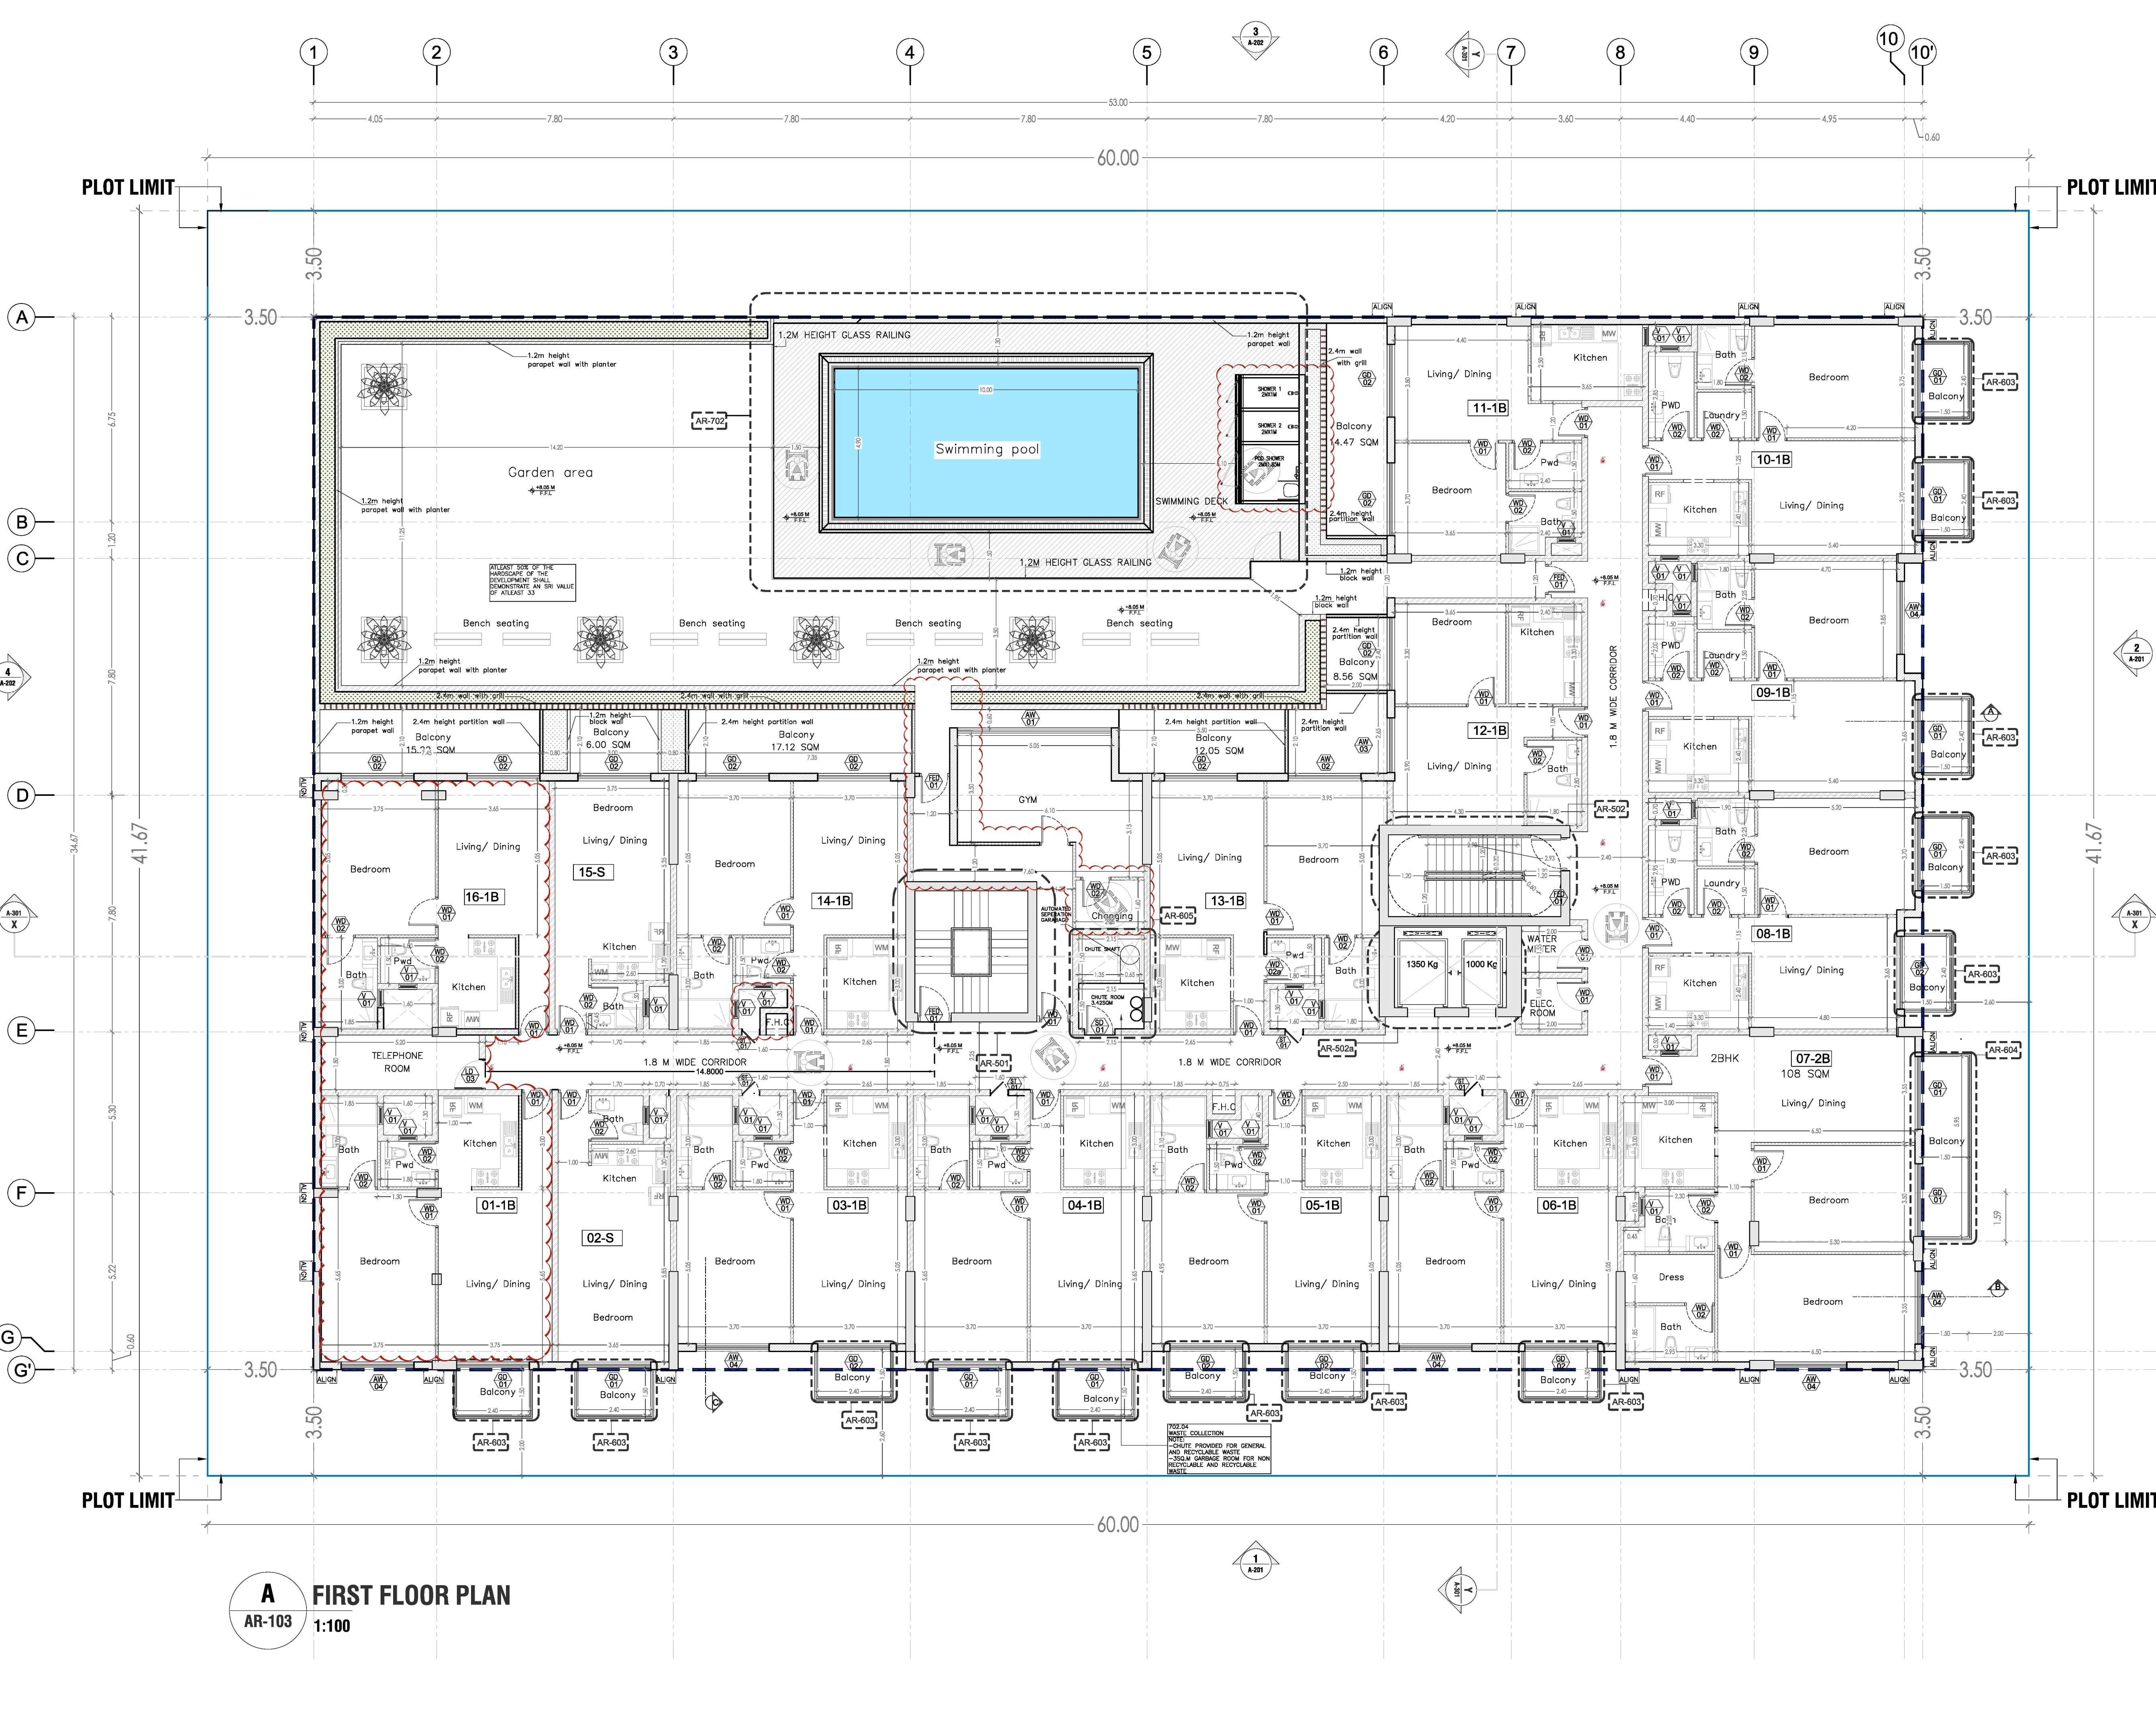

- GENERAL NOTES:**
1. ALL DIMENSIONS ARE IN MILLIMETERS. UNLESS OTHERWISE SPECIFIED.
 2. DO NOT SCALE THE DRAWINGS.
 3. ALL MATERIALS SHOULD BE APPROVED BY THE CONSULTANT.
 4. DO NOT COVER ANY INTERNAL EXECUTION WORKS BEFORE CHECKED AND APPROVED BY THE CONSULTANT.
 5. DO NOT COMMENCE THE WORK UNLESS THE DRAWING IS ISSUED FOR CONSTRUCTION.
 6. CONTRACTOR SHOULD SUBMIT THE SHOP DRAWING FOR APPROVAL.
 7. EXAMINE THE DRAWINGS, CAREFULLY BEFORE COMMENCING THE WORKS. REPORT TO THE CONSULTANT AND OBTAIN CLARIFICATIONS OR ADDITIONAL INSTRUCTIONS BEFORE PROCEEDING.
 8. ALL PLANS, DRAWINGS, GRAPHICS REPRESENTATIONS, AND SPECIFICATIONS PREPARED BY THE CONSULTANT ARE INSTRUMENT OF SERVICES FOR CARRYING OUT A PROJECT.

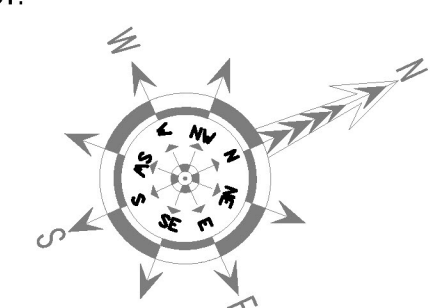


---	SETBACK LINE
---	PROPOSED BUILDING LINE
---	PLOT LIMIT

AS REVISED




MINOR MODIFICATION AS PER DCD		08.07.2024	R1
DESCRIPTION		DATE	REV
CONSULTANT:			
CORPORATE PLANNERS			
ENGINEERING CONSULTANTS			
P.O. Box 31548, DUBAI UNITED ARAB EMIRATES.			
Tel: +966-4-2779058 Fax: +966-4-2779059, Email: cpec@cpecdxb.ae			
CLIENT:			
MR. FIROZ LATIF MANJOTHI			
JOB TITLE:			
PROPOSED G+P+4+R APARTMENT			
@ INTERNATIONAL CITY PHASE 2 AND 3			
ON PLOT NO IC3-D-02			
DRAWING TITLE:			
FIRST FLOOR PLAN			
JOB NO.	DATE	SCALE	REV
1 : 100	NOV 2023	1 : 100	R1
CORPORATE PLANNERS ENGINEERING CONSULTANTS reserve the ownership of this drawing under the law. All rights on this drawing rest at all times with our company. This drawing is issued on the condition that it is not copied, reproduced, related or disclosed to any unauthorized person either wholly or in part without the consent in writing of the CORPORATE PLANNERS ENGINEERING CONSULTANTS.			
DRAWING NO.: AR-103			

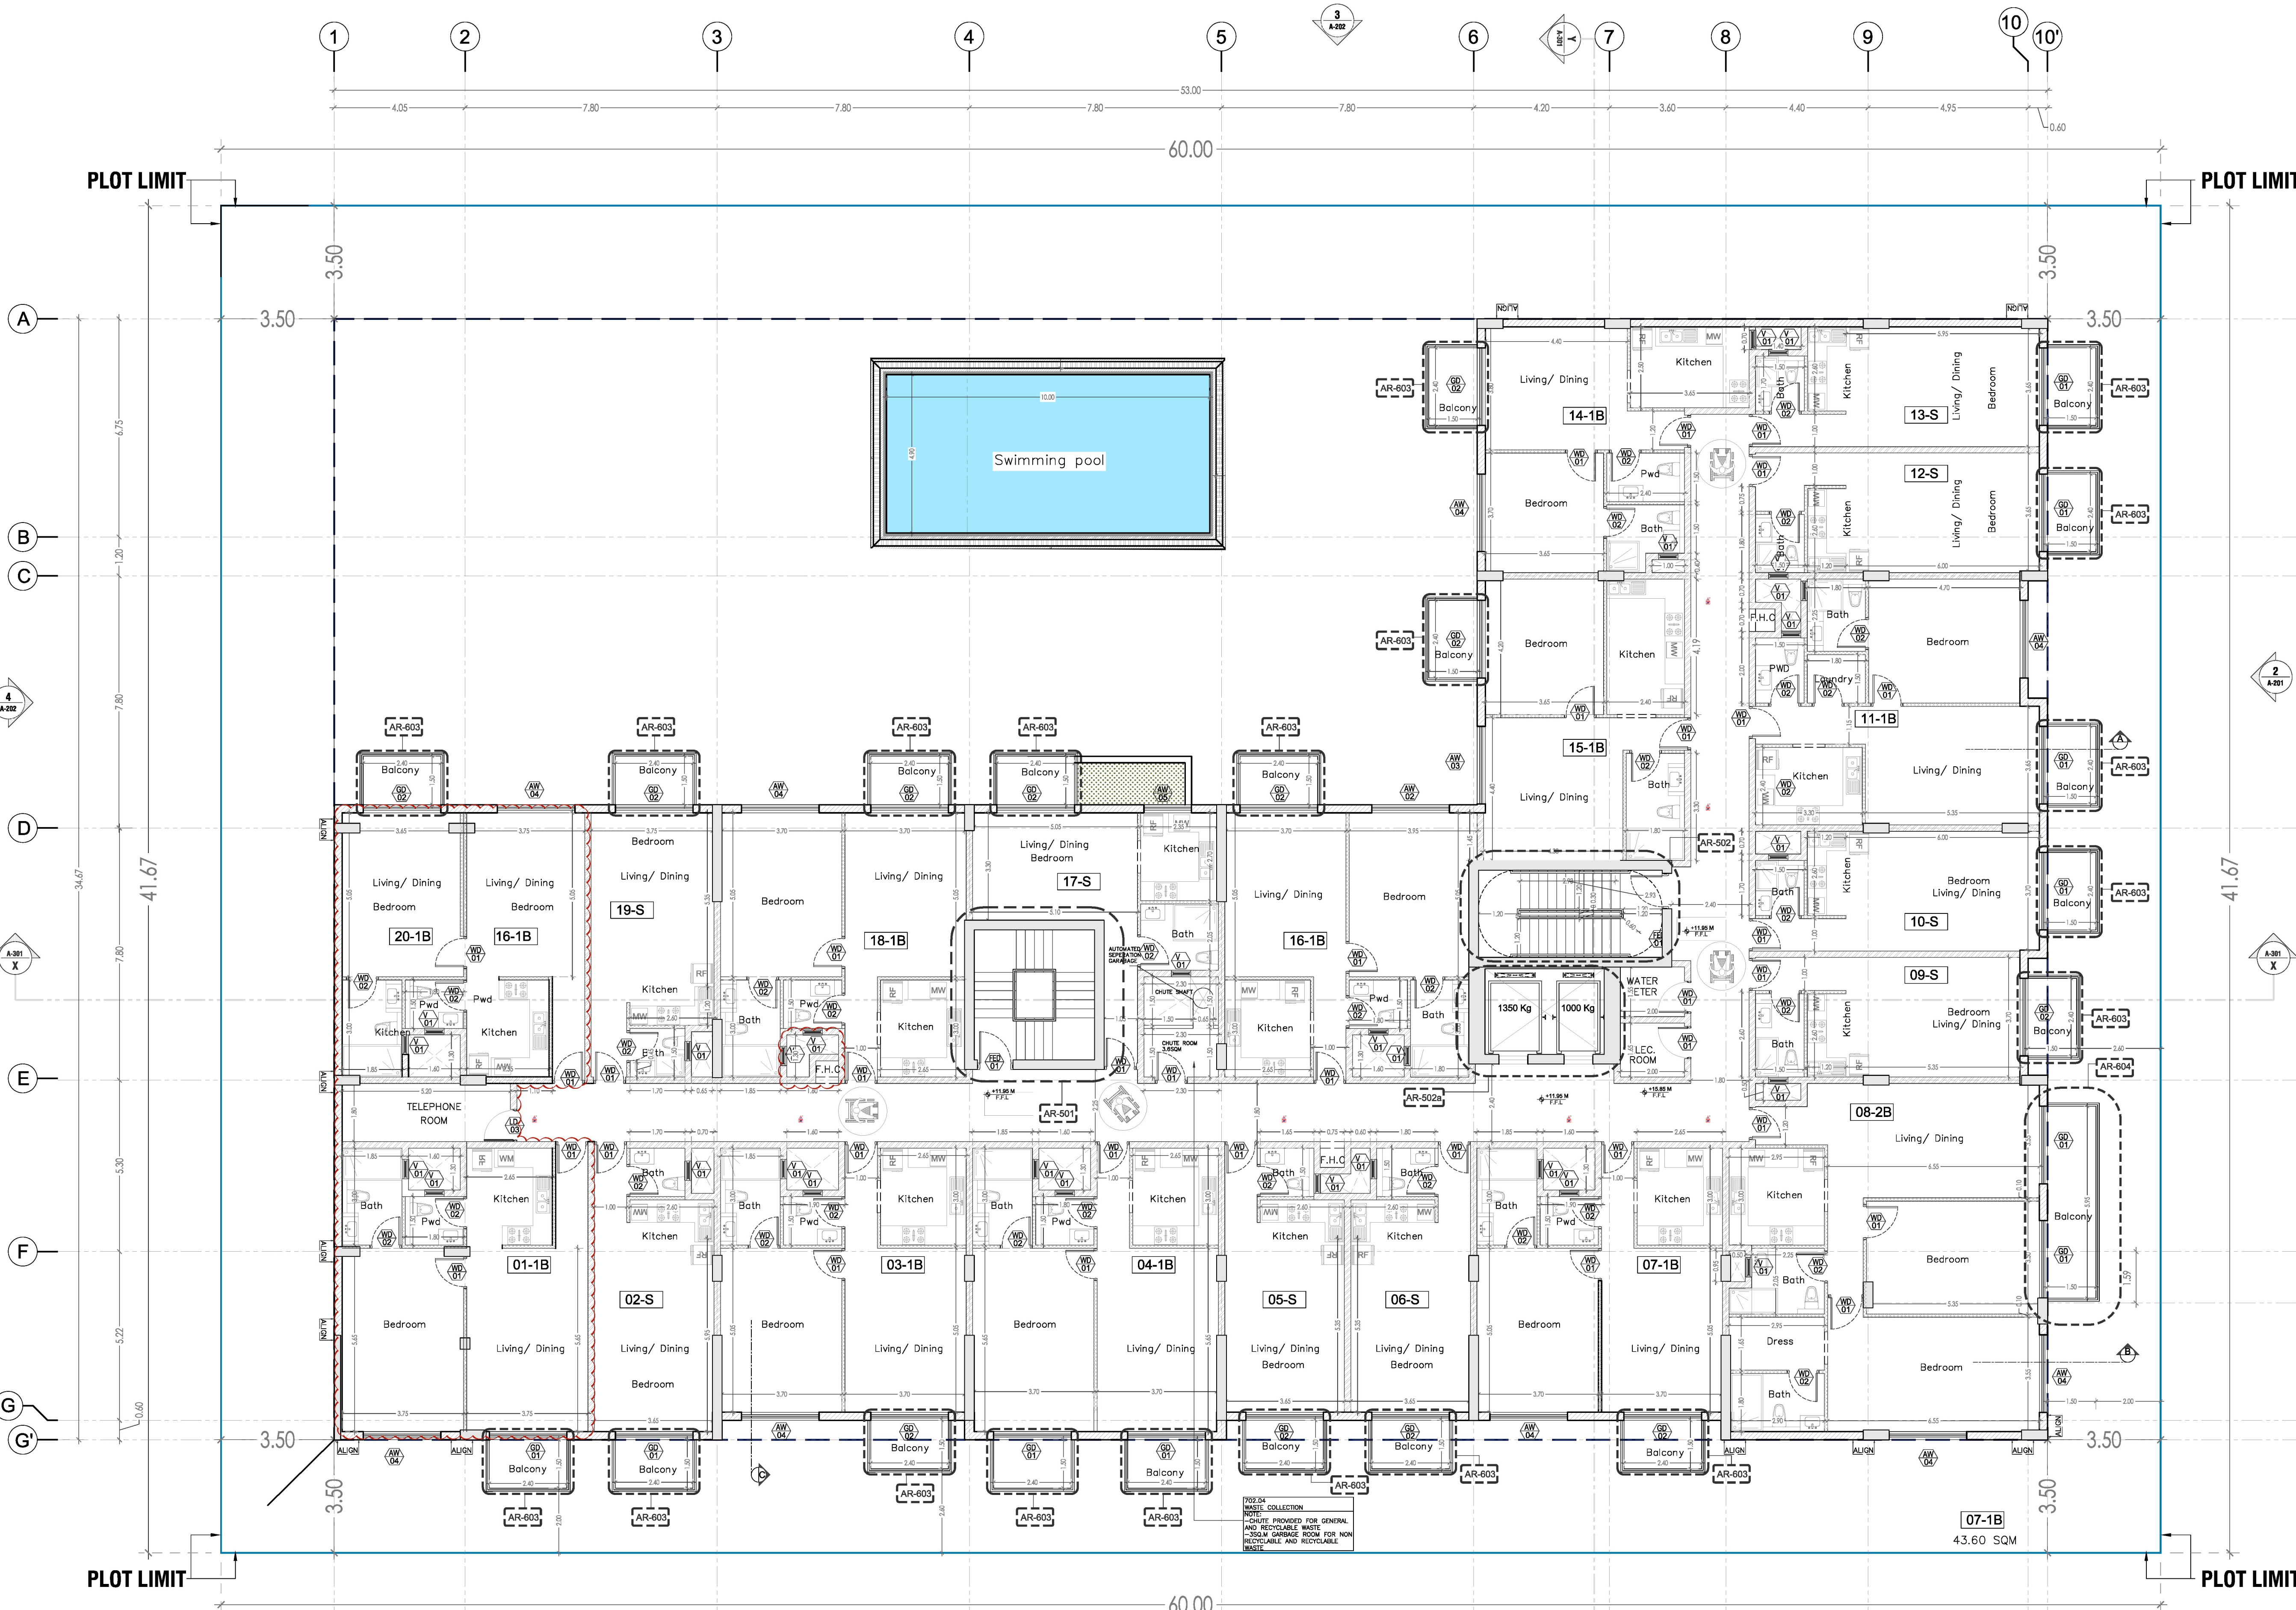

A
AR-104
SECOND FLOOR PLAN
1:100

- GENERAL NOTES:**
1. ALL DIMENSIONS ARE IN MILLIMETERS. UNLESS OTHERWISE SPECIFIED.
 2. DO NOT SCALE THE DRAWINGS.
 3. ALL MATERIALS SHOULD BE APPROVED BY THE CONSULTANT.
 4. DO NOT COVER ANY INTERNAL EXECUTION WORKS BEFORE CHECKED AND APPROVED BY THE CONSULTANT.
 5. DO NOT COMMENCE THE WORK UNLESS THE DRAWING IS ISSUED FOR CONSTRUCTION.
 6. CONTRACTOR SHOULD SUBMIT THE SHOP DRAWING FOR APPROVAL.
 7. EXAMINE THE DRAWINGS, CAREFULLY BEFORE COMMENCING THE WORKS. REPORT TO THE CONSULTANT AND OBTAIN CLARIFICATIONS OR ADDITIONAL INSTRUCTIONS BEFORE PROCEEDING.
 8. ALL PLANS, DRAWINGS, GRAPHICS REPRESENTATIONS, AND SPECIFICATIONS PREPARED BY THE CONSULTANT ARE INSTRUMENT OF SERVICES FOR CARRYING OUT A PROJECT.

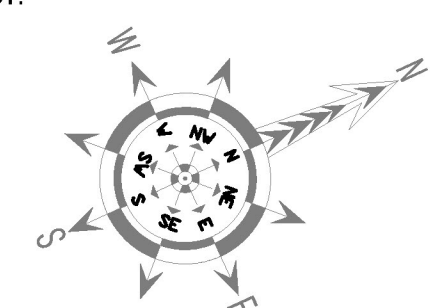


LEGEND

---	SETBACK LINE
---	PROPOSED BUILDING LINE
---	PLOT LIMIT


AS REVISED



MINOR MODIFICATION AS PER DCD	08.07.2024	R1
DESCRIPTION	DATE	REV
CONSULTANT:		
CORPORATE PLANNERS		
ENGINEERING CONSULTANTS		
P.O. Box 31548, DUBAI, UNITED ARAB EMIRATES.		
Tel: -04-2779058 Fax: -04-2779059, Email: cpec@cpecdxb.ae		
CLIENT:		
MR. FIROZ LATIF MANJOTHI		
JOB TITLE:		
PROPOSED G+P+4+R APARTMENT @ INTERNATIONAL CITY PHASE 2 AND 3 ON PLOT NO IC3-D-02		
DRAWING TITLE:		
SECOND FLOOR PLAN		
JOB NO.	DRAWN	SARA
SCALE: 1:100	DATE: NOV 2023	STRUC.
CORPORATE PLANNERS ENGINEERING CONSULTANTS reserve the ownership of this drawing under the law. All rights on this drawing rest at all times with our company. This drawing is issued on the condition that it is not copied, reproduced, related or disclosed to any unauthorized person either wholly or in part without the consent in writing of the CORPORATE PLANNERS ENGINEERING CONSULTANTS.		
DRAWING NO.: AR-104		REV. R1

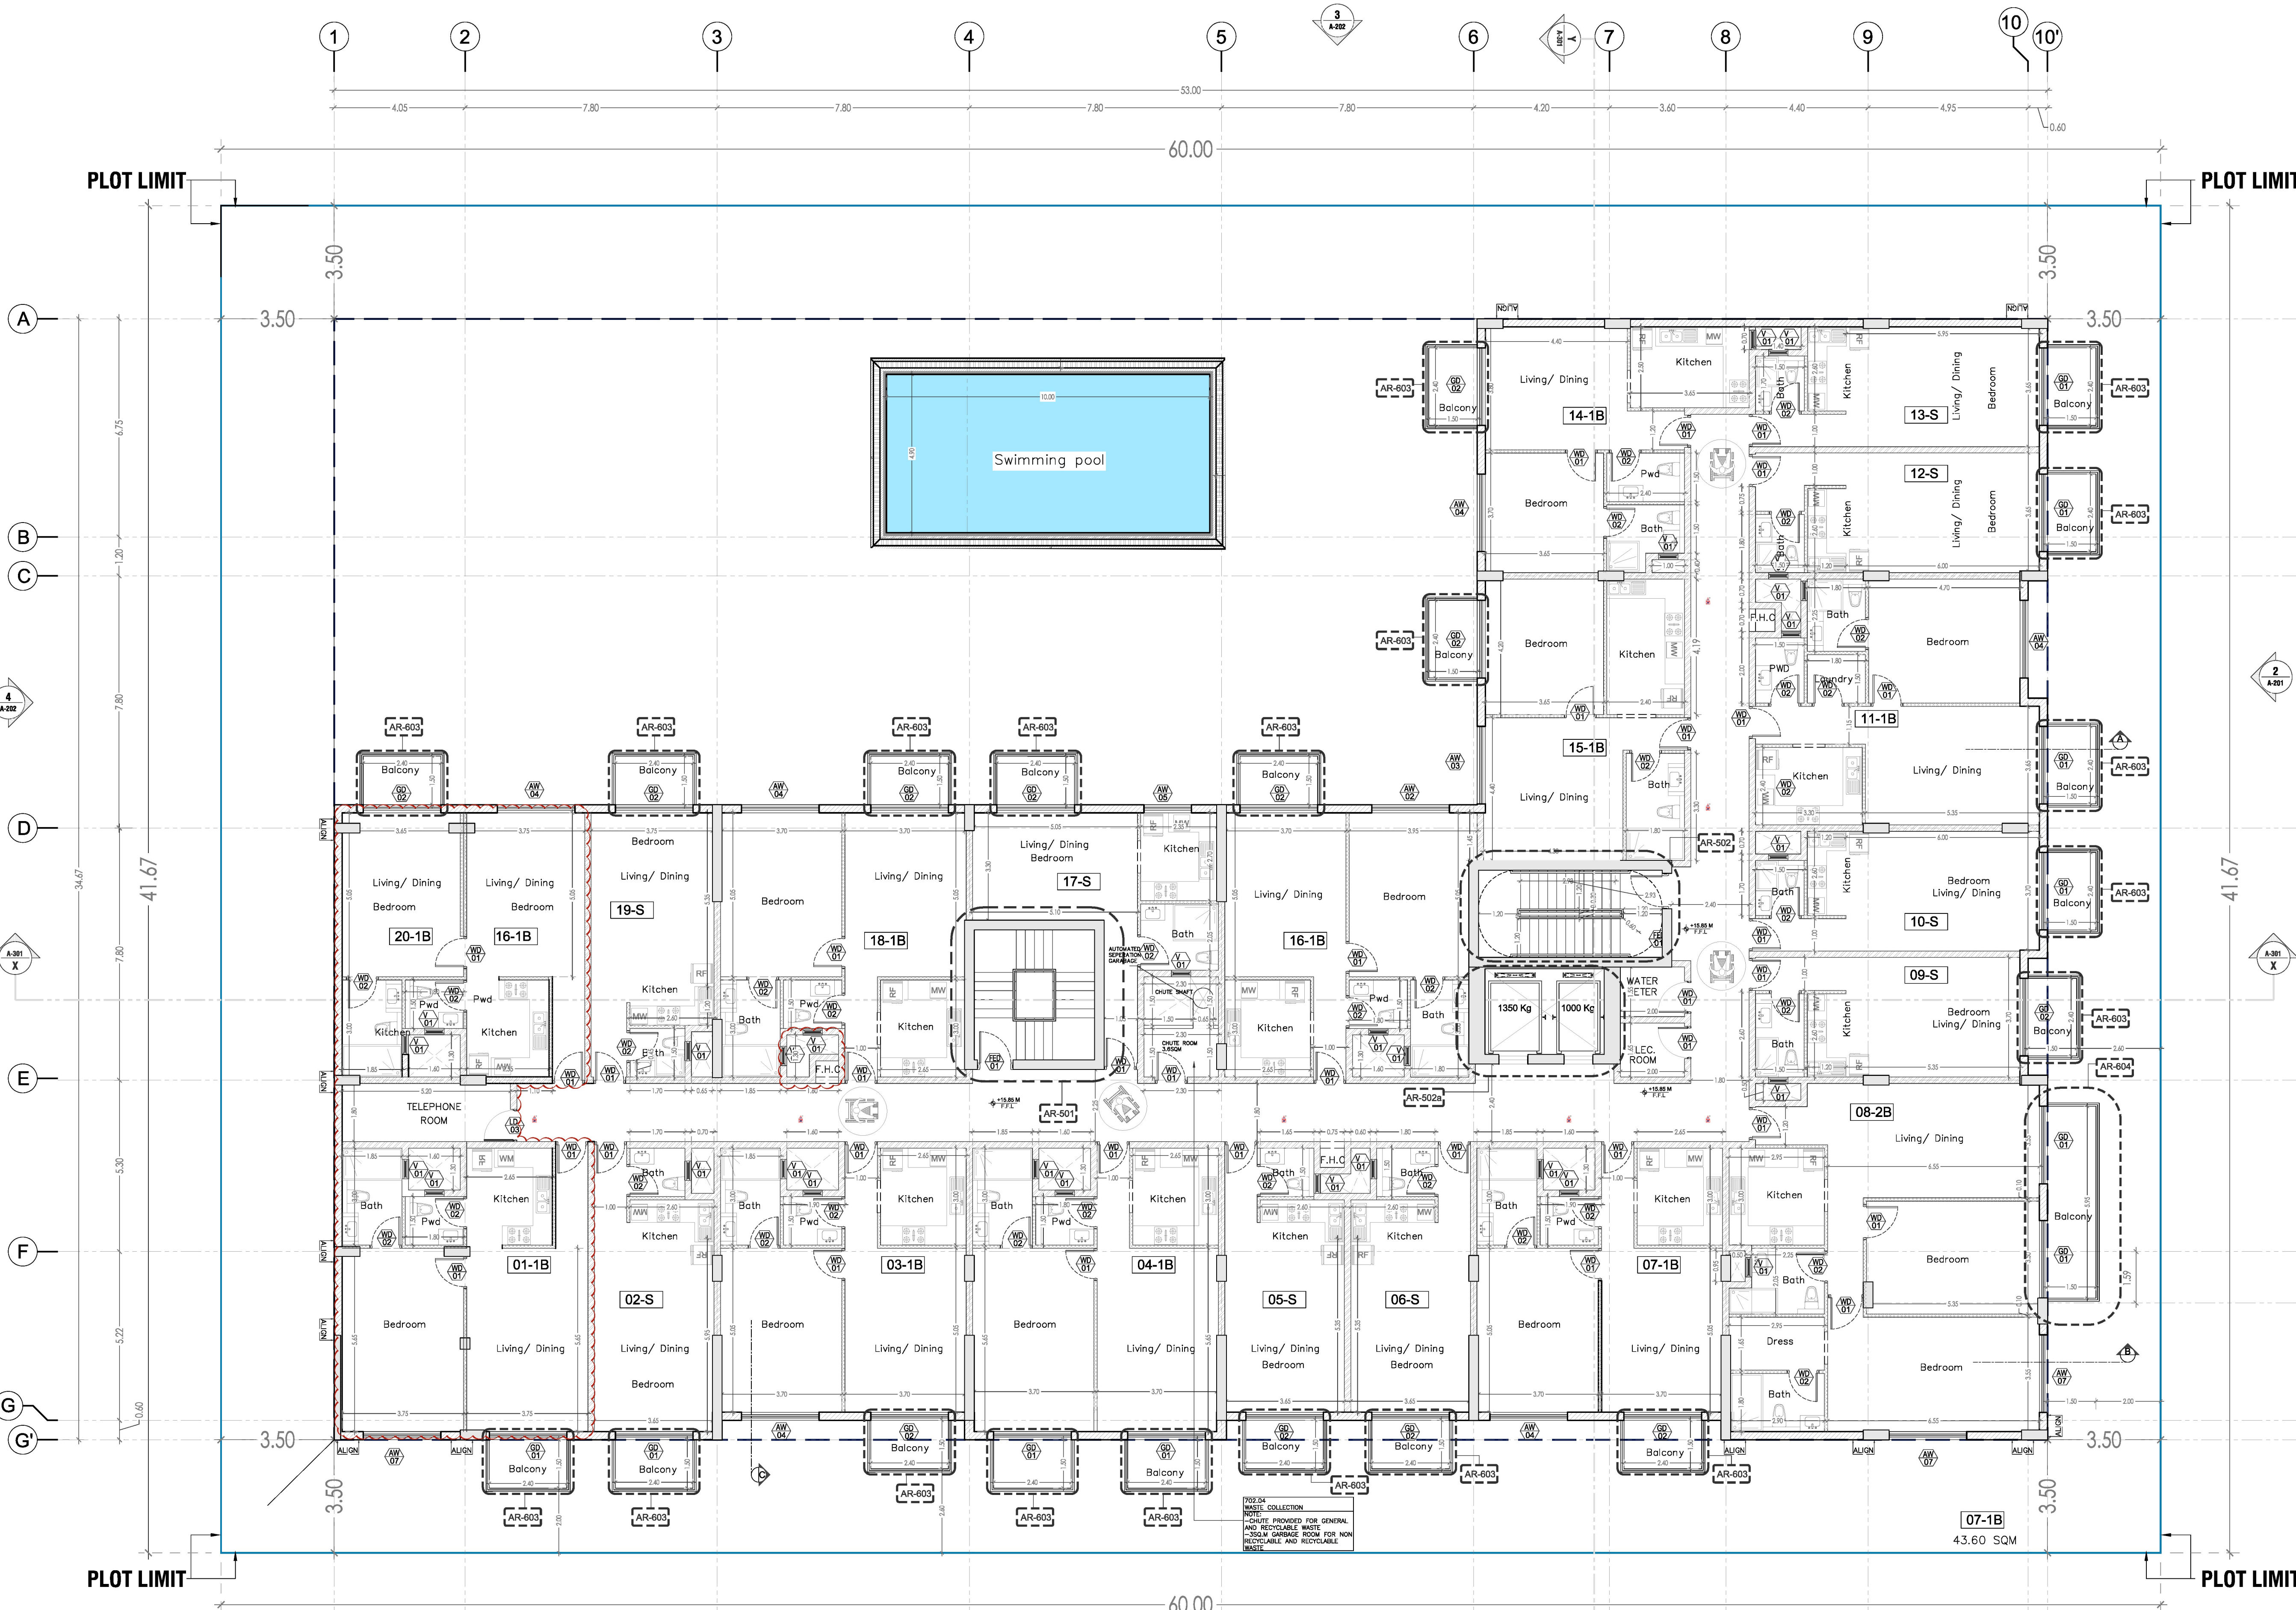

- GENERAL NOTES:**
1. ALL DIMENSIONS ARE IN MILLIMETERS. UNLESS OTHERWISE SPECIFIED.
 2. DO NOT SCALE THE DRAWINGS.
 3. ALL MATERIALS SHOULD BE APPROVED BY THE CONSULTANT.
 4. DO NOT COVER ANY INTERNAL EXECUTION WORKS BEFORE CHECKED AND APPROVED BY THE CONSULTANT.
 5. DO NOT COMMENCE THE WORK UNLESS THE DRAWING IS ISSUED FOR CONSTRUCTION.
 6. CONTRACTOR SHOULD SUBMIT THE SHOP DRAWING FOR APPROVAL.
 7. EXAMINE THE DRAWINGS, CAREFULLY BEFORE COMMENCING THE WORKS. REPORT TO THE CONSULTANT AND OBTAIN CLARIFICATIONS OR ADDITIONAL INSTRUCTIONS BEFORE PROCEEDING.
 8. ALL PLANS, DRAWINGS, GRAPHICS REPRESENTATIONS, AND SPECIFICATIONS PREPARED BY THE CONSULTANT ARE INSTRUMENT OF SERVICES FOR CARRYING OUT A PROJECT.

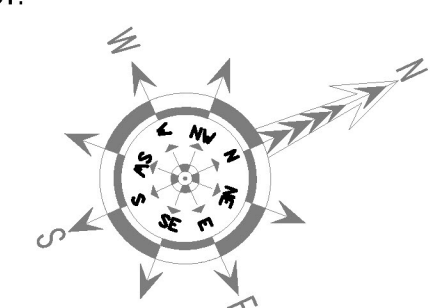


---	SETBACK LINE
---	PROPOSED BUILDING LINE
---	PLOT LIMIT

AS REVISED




MINOR MODIFICATION AS PER DCD	08.07.2024	R1
DESCRIPTION	DATE	REV
CONSULTANT:		
CORPORATE PLANNERS		
ENGINEERING CONSULTANTS		
P.O. Box 31548, DUBAI, UNITED ARAB EMIRATES.		
Tel: +966-11-2779058 Fax: +966-11-2779059 Email: cpec@cpecdxb.ae		
CLIENT:		
MR. FIROZ LATIF MANJOTHI		
JOB TITLE:		
PROPOSED G+P+4+R APARTMENT @ INTERNATIONAL CITY PHASE 2 AND 3 ON PLOT NO IC3-D-02		
DRAWING TITLE:		
THIRD FLOOR PLAN		
JOB NO.	DRAWN	SARA
SCALE: 1:100	DATE: NOV 2023	STRUC.
CORPORATE PLANNERS ENGINEERING CONSULTANTS reserve the ownership of this drawing under the law. All rights on this drawing rest at all times with our company. This drawing is issued on the condition that it is not copied, reproduced, related or disclosed to any unauthorized person either wholly or in part without the consent in writing of the CORPORATE PLANNERS ENGINEERING CONSULTANTS.		
DRAWING NO.: AR-105		

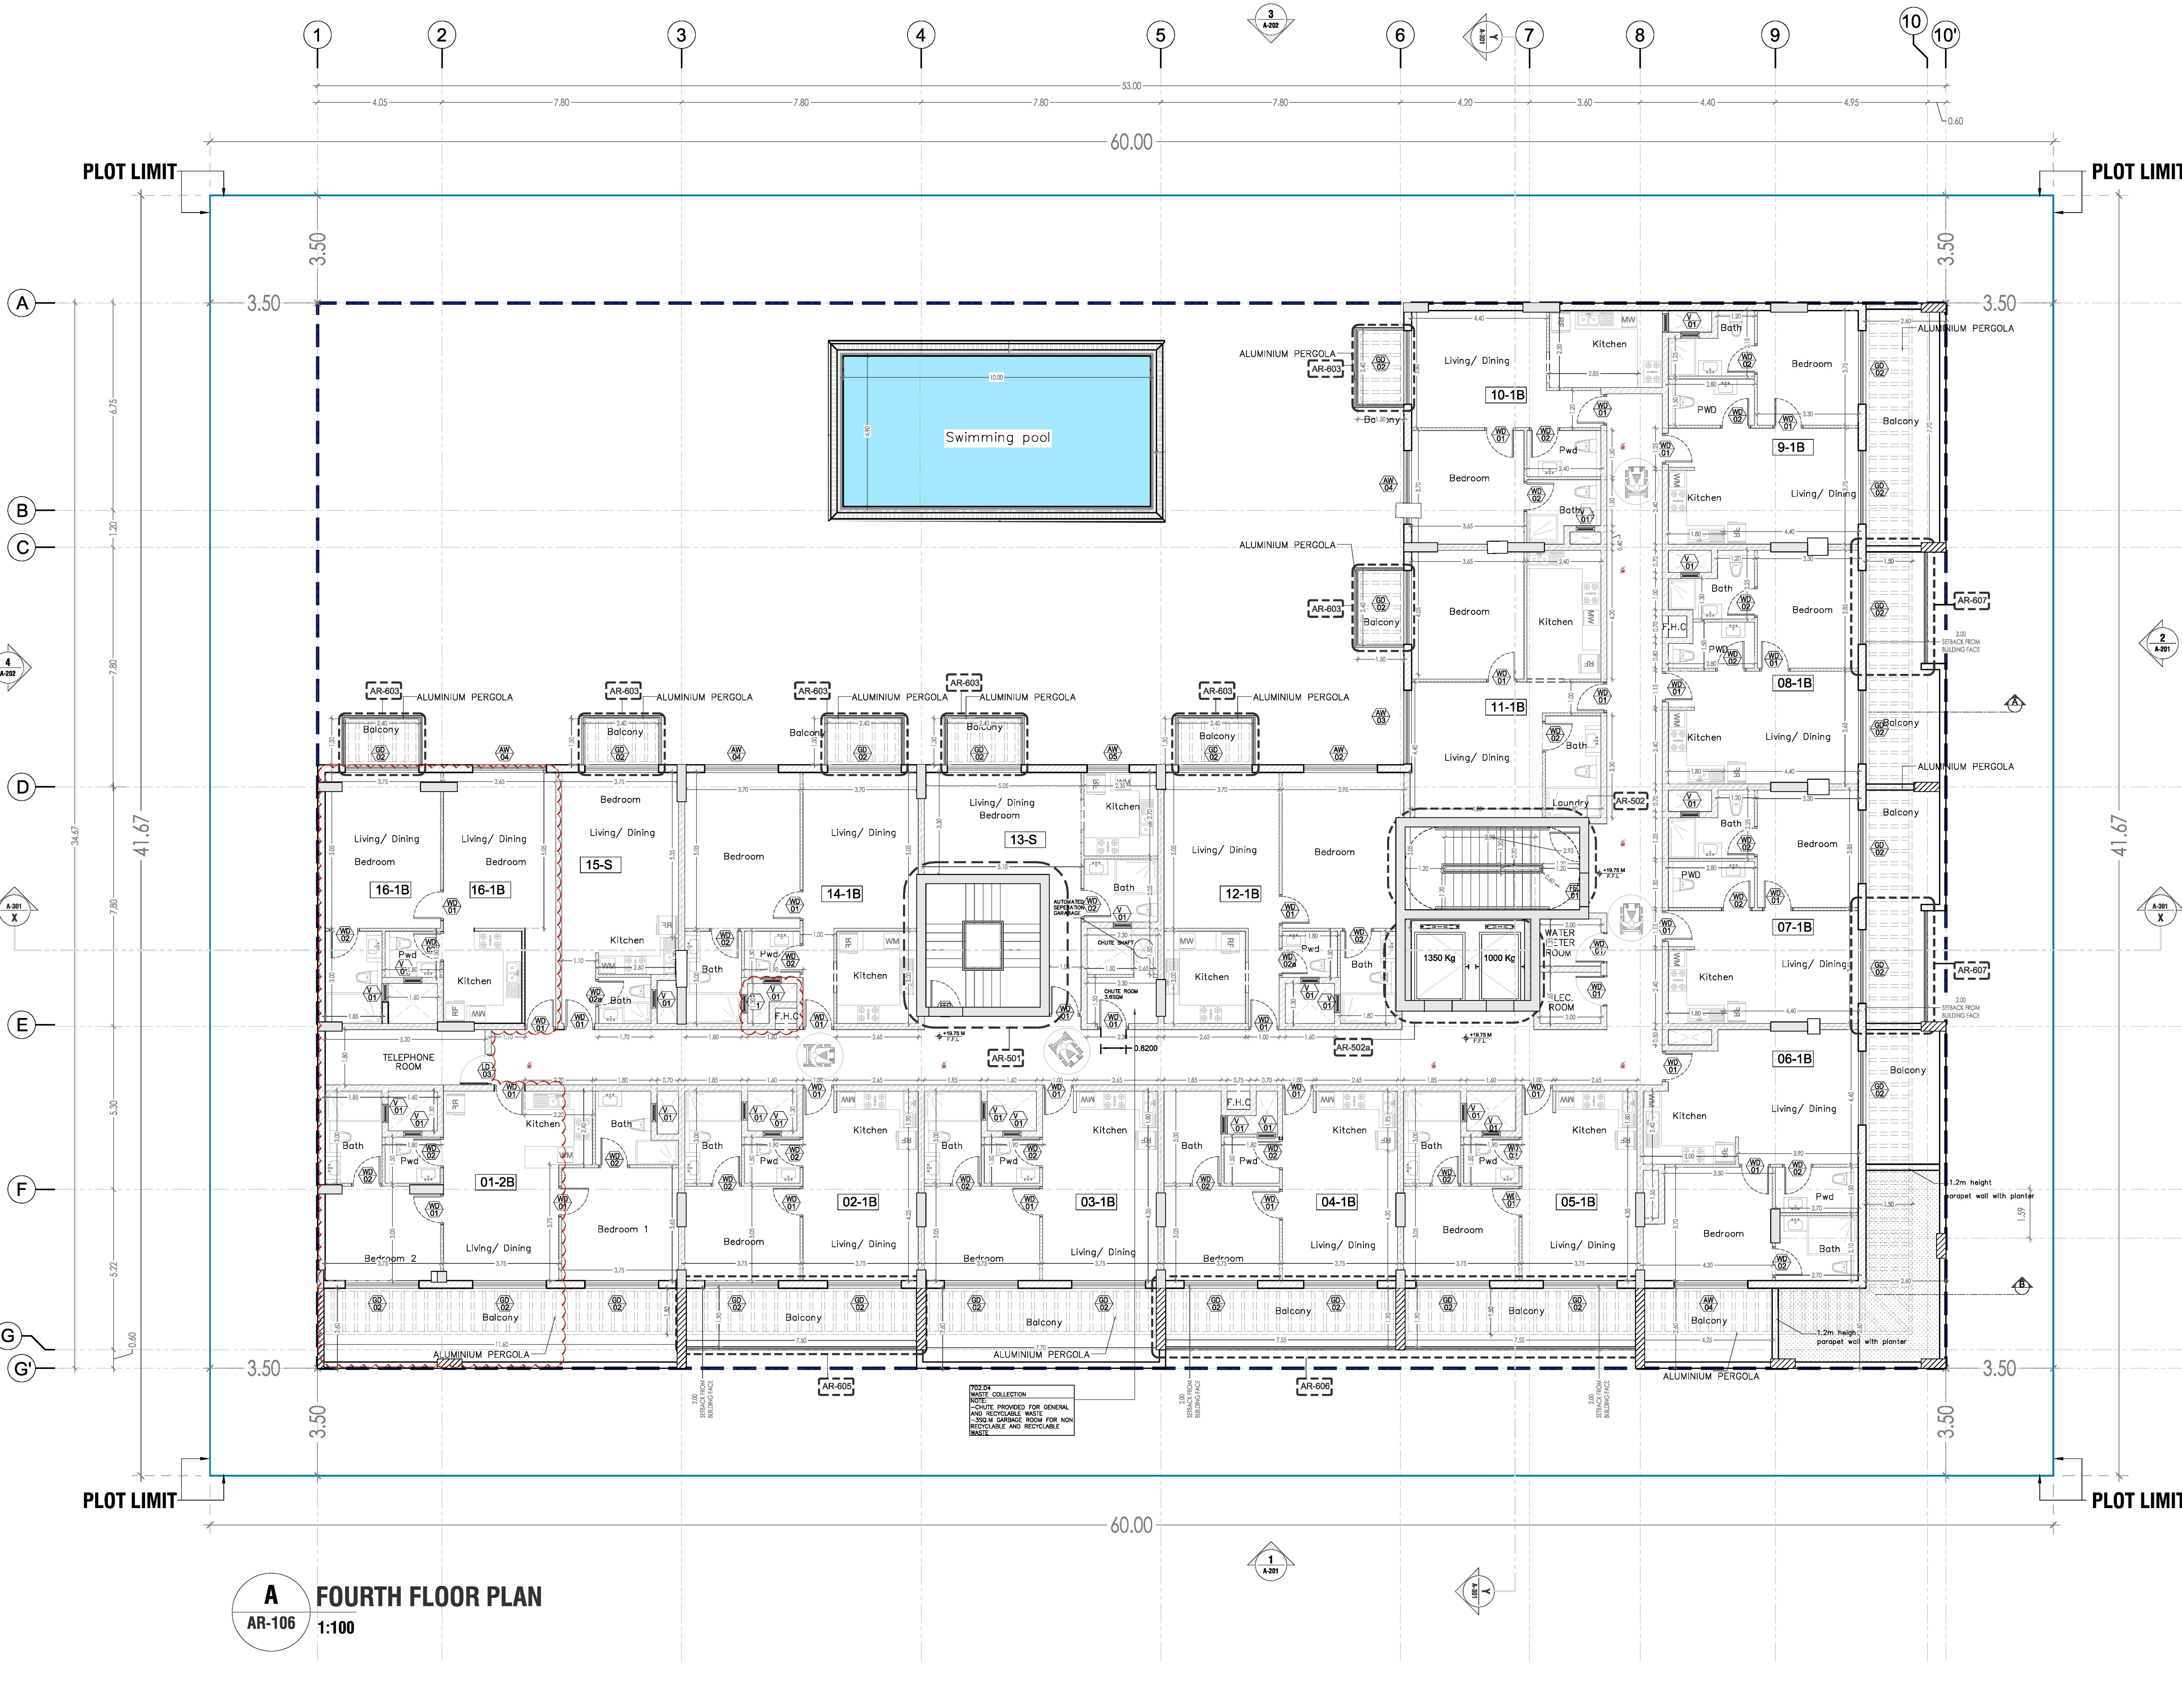

GENERAL NOTES:

1. ALL DIMENSIONS ARE IN MILLIMETERS. UNLESS OTHERWISE SPECIFIED.
2. DO NOT SCALE THE DRAWINGS.
3. ALL MATERIALS SHOULD BE APPROVED BY THE CONSULTANT.
4. DO NOT COVER ANY INTERNAL EXECUTION WORKS BEFORE CHECKED AND APPROVED BY THE CONSULTANT.
5. DO NOT COMMENCE THE WORK UNLESS THE DRAWING IS ISSUED FOR CONSTRUCTION.
6. CONTRACTOR SHOULD SUBMIT THE SHOP DRAWING FOR APPROVAL.
7. EXAMINE THE DRAWINGS, CAREFULLY BEFORE COMMENCING THE WORKS. REPORT TO THE CONSULTANT AND OBTAIN CLARIFICATIONS OR ADDITIONAL INSTRUCTIONS BEFORE PROCEEDING.
8. ALL PLANS, DRAWINGS, GRAPHICS REPRESENTATIONS, AND SPECIFICATIONS PREPARED BY THE CONSULTANT ARE INSTRUMENT OF SERVICES FOR CARRYING OUT A PROJECT.

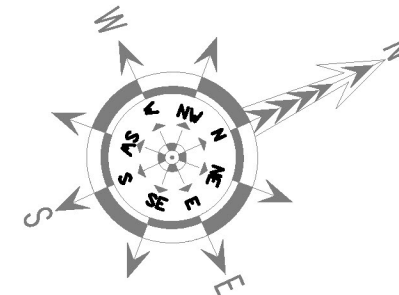

LEGEND

	SETBACK LINE
	PROPOSED BUILDING LINE
	PLOT LIMIT

AS REVISED



MINOR MODIFICATION AS PER DCD	08.07.2024	R1
DESCRIPTION	DATE	REV

CONSULTANT:

CORPORATE PLANNERS
ENGINEERING CONSULTANTS
P.O. Box 31548, DUBAI, UNITED ARAB EMIRATES.
Tel: -04-2779058 Fax: -04-2779059, Email: cpec@cpcedxb.ae

CLIENT:

MR. FIROZ LATIF MANJOTHI

JOB TITLE:

PROPOSED G+P+4+R APARTMENT
@ INTERNATIONAL CITY PHASE 2 AND 3
ON PLOT NO IC3-D-02

DRAWING TITLE:

FOURTH FLOOR PLAN

JOB NO.	SCALE:	DATE:	NOV 2023	ARCH:	Farooq
1 : 100	DRAWN:	NOV 2023	STRUC.		

CORPORATE PLANNERS ENGINEERING CONSULTANTS reserve the ownership of this drawing under the law. All rights on this drawing rest at all times with our company. This drawing is issued on the condition that it is not copied, reproduced, related or disclosed to any unauthorized person either wholly or in part without the consent in writing of the CORPORATE PLANNERS ENGINEERING CONSULTANTS.

DRAWING NO.: AR-106

REV: R1

A
AR-106
FOURTH FLOOR PLAN
1:100